


33kV 配电装置  
33kV SWITCHGEAR

箱式变压器  
Combined Transformer  
3150kVA D,yn11 Ud=7%  
36.5±2X2.5%/0.8

3125kW 逆变器 INVERTER (含直流配电柜)

直流汇流箱 24汇1  
DC COMBINER BOX  
24 in and 1 out

battery  
额定功率 Rated Power 550Wp  
开路电压 Open Circuit voltage 49.8V  
短路电流 Short Circuit Current 13.99A  
峰值电压 Peak voltage 41.80A  
峰值电流 Peak Current 13.04A  
组串 PV String 28Set/String

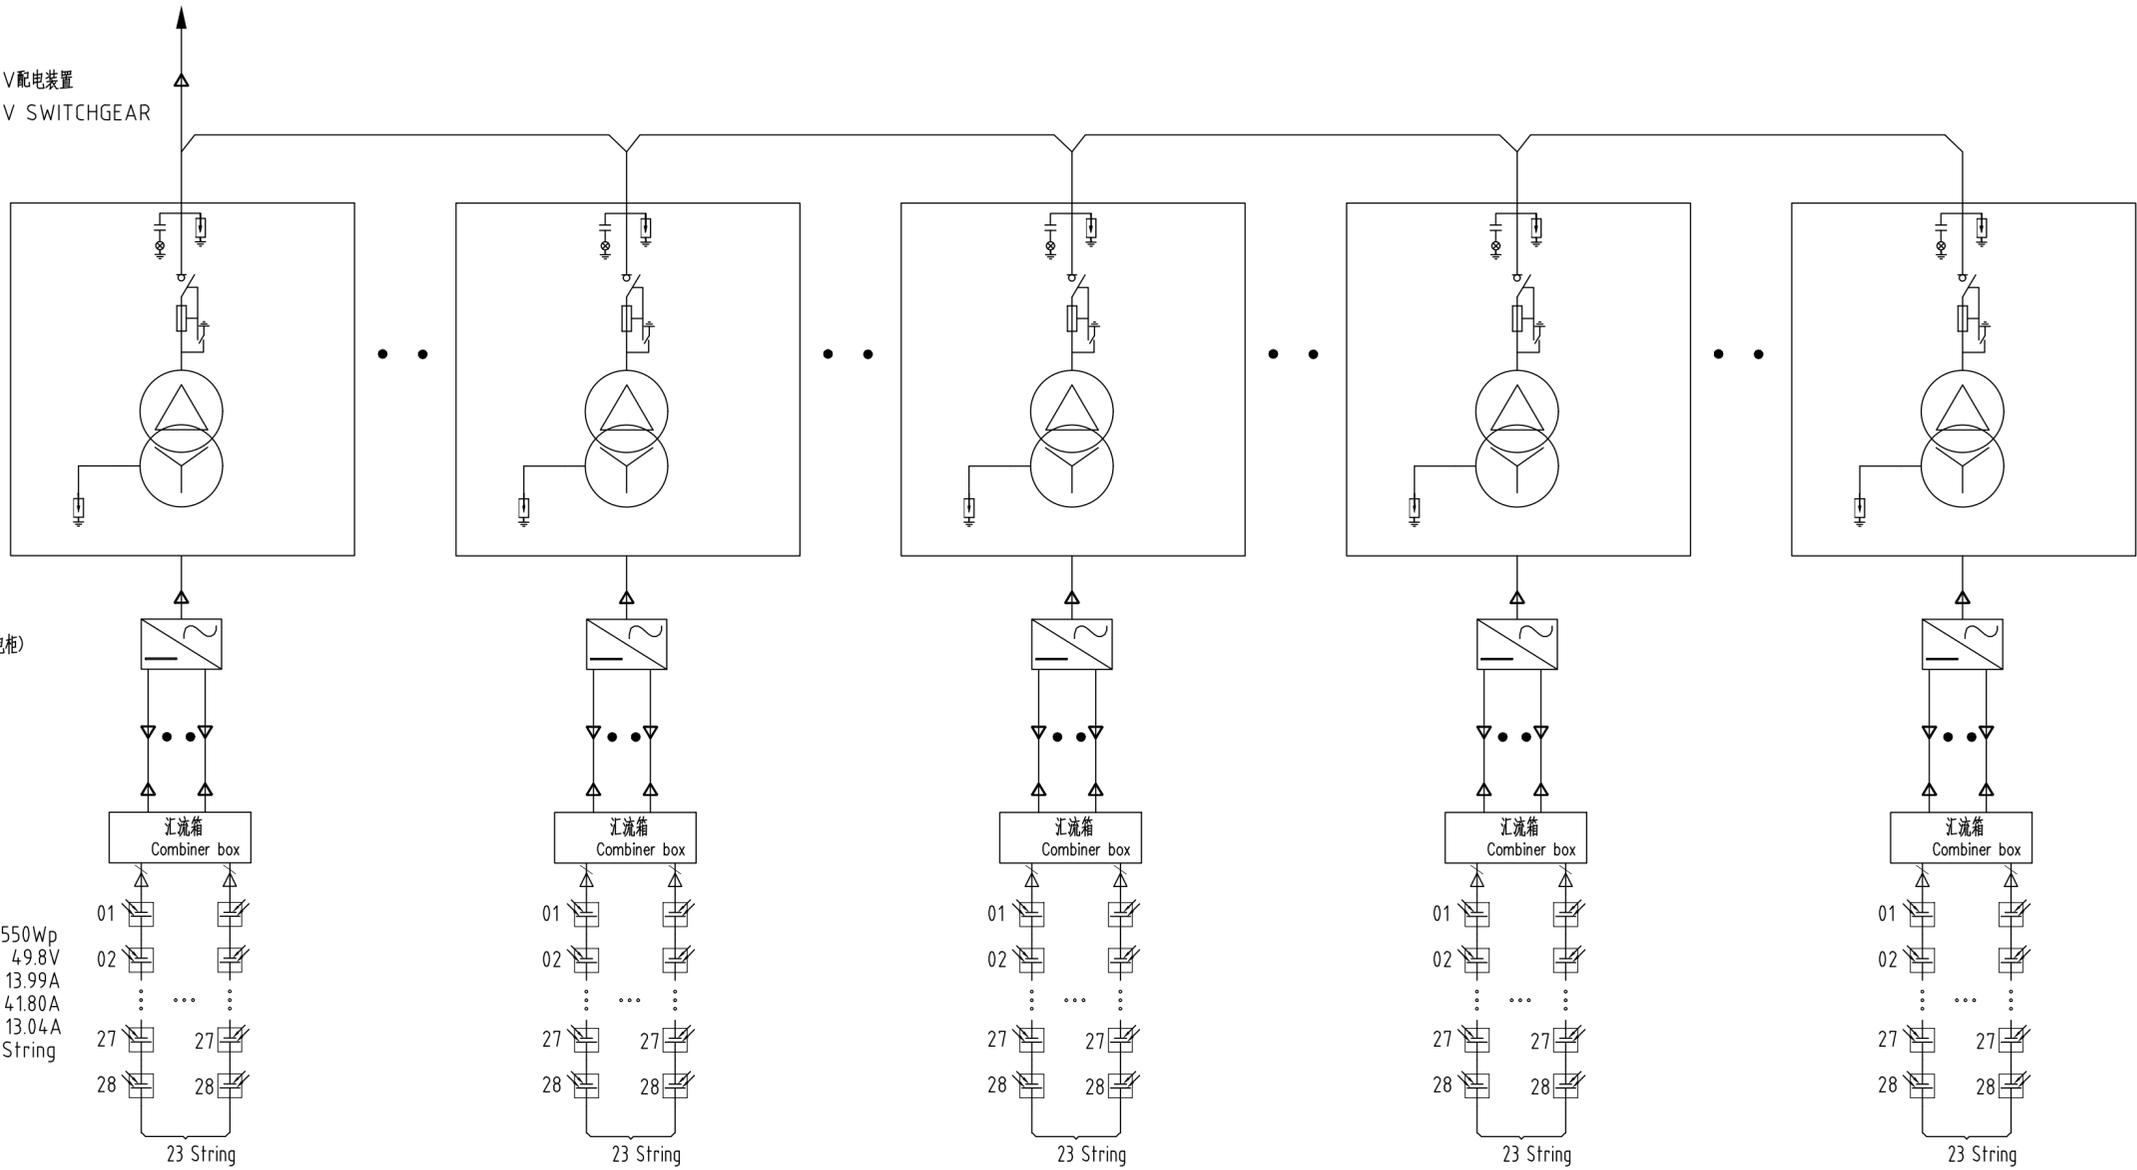

<p><b>COPYRIGHT STATEMENT:</b> THE COPYRIGHT OF THIS DOCUMENT IS OWNED BY SDEPCI AND TO BE USED SOLELY FOR THIS PROJECT. THE DOCUMENT AND RELATIVE INFORMATION IS NOT TO BE TRANSMITTED, DISCLOSED TO THE THIRD PARTY OR USED FOR OTHER PROJECTS WITHOUT AUTHORIZATION OF SDEPCI.</p>					
<p>CLIENT DRAWING NO.</p>					
<p>CLIENT:</p>			<p>CONTRACT:</p>		
<p>SHANDONG ELECTRIC POWER ENGINEERING CONSULTING INSTITUTE CORP., LTD.</p>		<p>PROJECT</p> <p>THE INTEGRATED GAS, PV AND ENERGY STORAGE PROJECT OF MAHESHKHALI IN BANGLADESH 孟加拉孟斯哈里气光储一体化电站项目</p>		<p>DESIGN PHASE</p> <p>FEASIBILITY STUDY</p>	
<p>APPRD.</p> <p>RVWD.</p> <p>SCALE</p>	<p>傅的</p> <p>董建康</p> <p>史朝晖</p>	<p>CHKD.</p> <p>DSGD.</p> <p>DATE</p>	<p>李晓庆</p> <p>董建康</p> <p>03.2023</p>	<p>箱式变电站一次接线图</p> <p>LINE DIAGRAM OF Combined Transformer</p>	
<p>1:-</p>		<p>03.2023</p>		<p>DWG. NO.</p> <p>B7-FA24281K-D-05</p>	<p>REV.</p>