
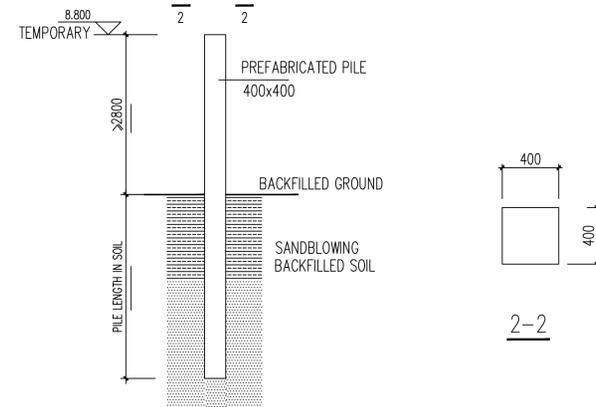


FOUNDATION FOR BOX TRANSFORMER 1:50

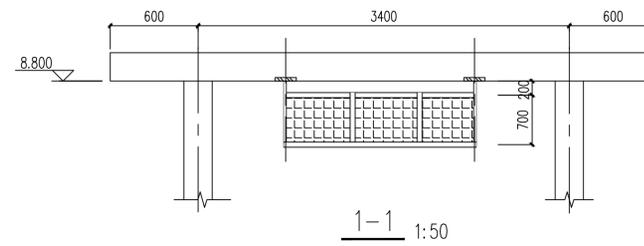

FOUNDATION

COPYRIGHT STATEMENT:
 THE COPYRIGHT OF THIS DOCUMENT IS OWNED BY SDEPCI AND TO BE USED SOLELY FOR THIS PROJECT.
 THE DOCUMENT AND RELATIVE INFORMATION IS NOT TO BE TRANSMITTED, DISCLOSED TO THE THIRD
 PARTY OR USED FOR OTHER PROJECTS WITHOUT AUTHORIZATION OF SDEPCI.

CLIENT DRAWING NO.

CLIENT: SHANDONG ELECTRIC POWER ENGINEERING CONSULTING INSTITUTE CORP., LTD.

CONTRACT:

PROJECT: 160MW(AC) Grid-Tied Solar power plant at Madeshkhall, Cox, Bazar, Bangladesh.

DESIGN. PHASE: FEASIBILITY STUDY

APPRD. 塔明 CHKD. 沈伟利

RVWD. 董建康 DSGD. 李松

SCALE: 1:100 DATE: 2022.09 DWG. NO.: 37-FA24281K-T-02

专业	会	签	日期

REV.