


SINGLE LINE DIAGRAM OF PROPOSED CHANDGAON R/A 33/11KV GIS SUBSTATION

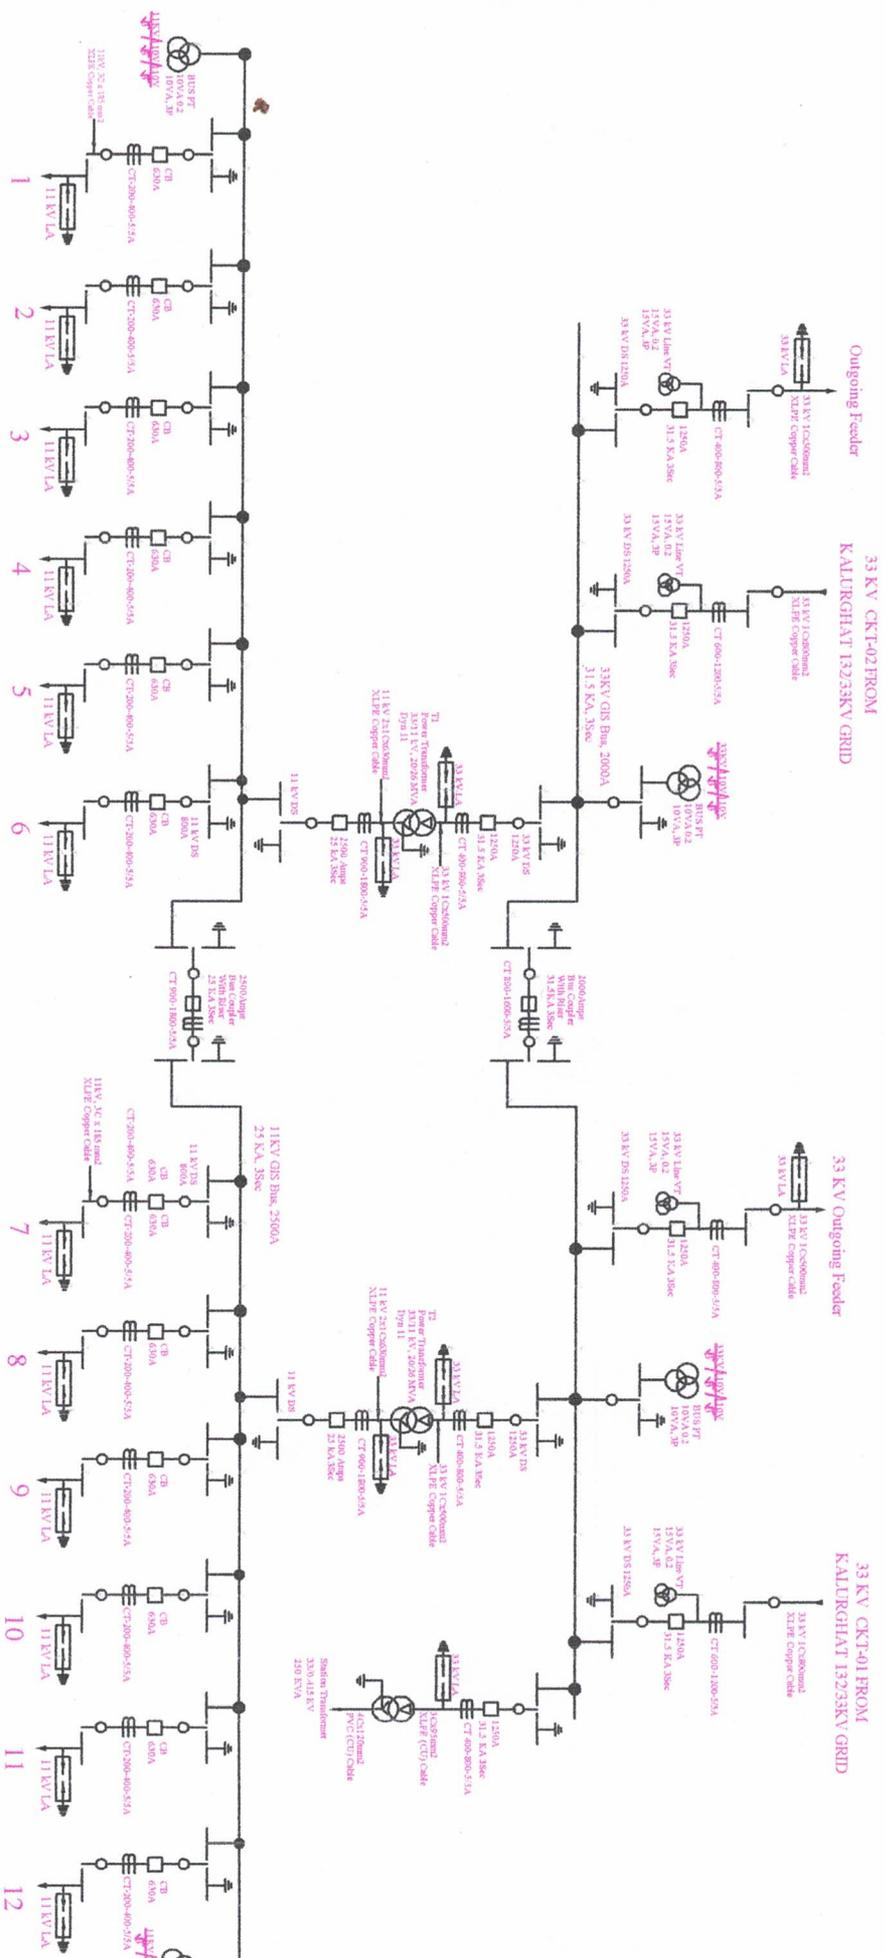

Sahajan
20.07.22

Engr. Satyendra Nath Chakraborty
Managing Director & T.L


Niaz & Associates Ltd.

Sahajan

M

| | |
|---------------|---|
| Project : | Power Distribution System Design |
| Title : | Single Line Diagram of Chandgaon R/A 33/11KV GIS Substation |
| Client : | Niaz & Associates |
| Drawing No. : | N-17 |
| Revision : | 03 |
| Date : | 20/07/22 |

SINGLE LINE DIAGRAM OF PROPOSED BARA DIGHIRPAR 33/11KV GIS SUBSTATION

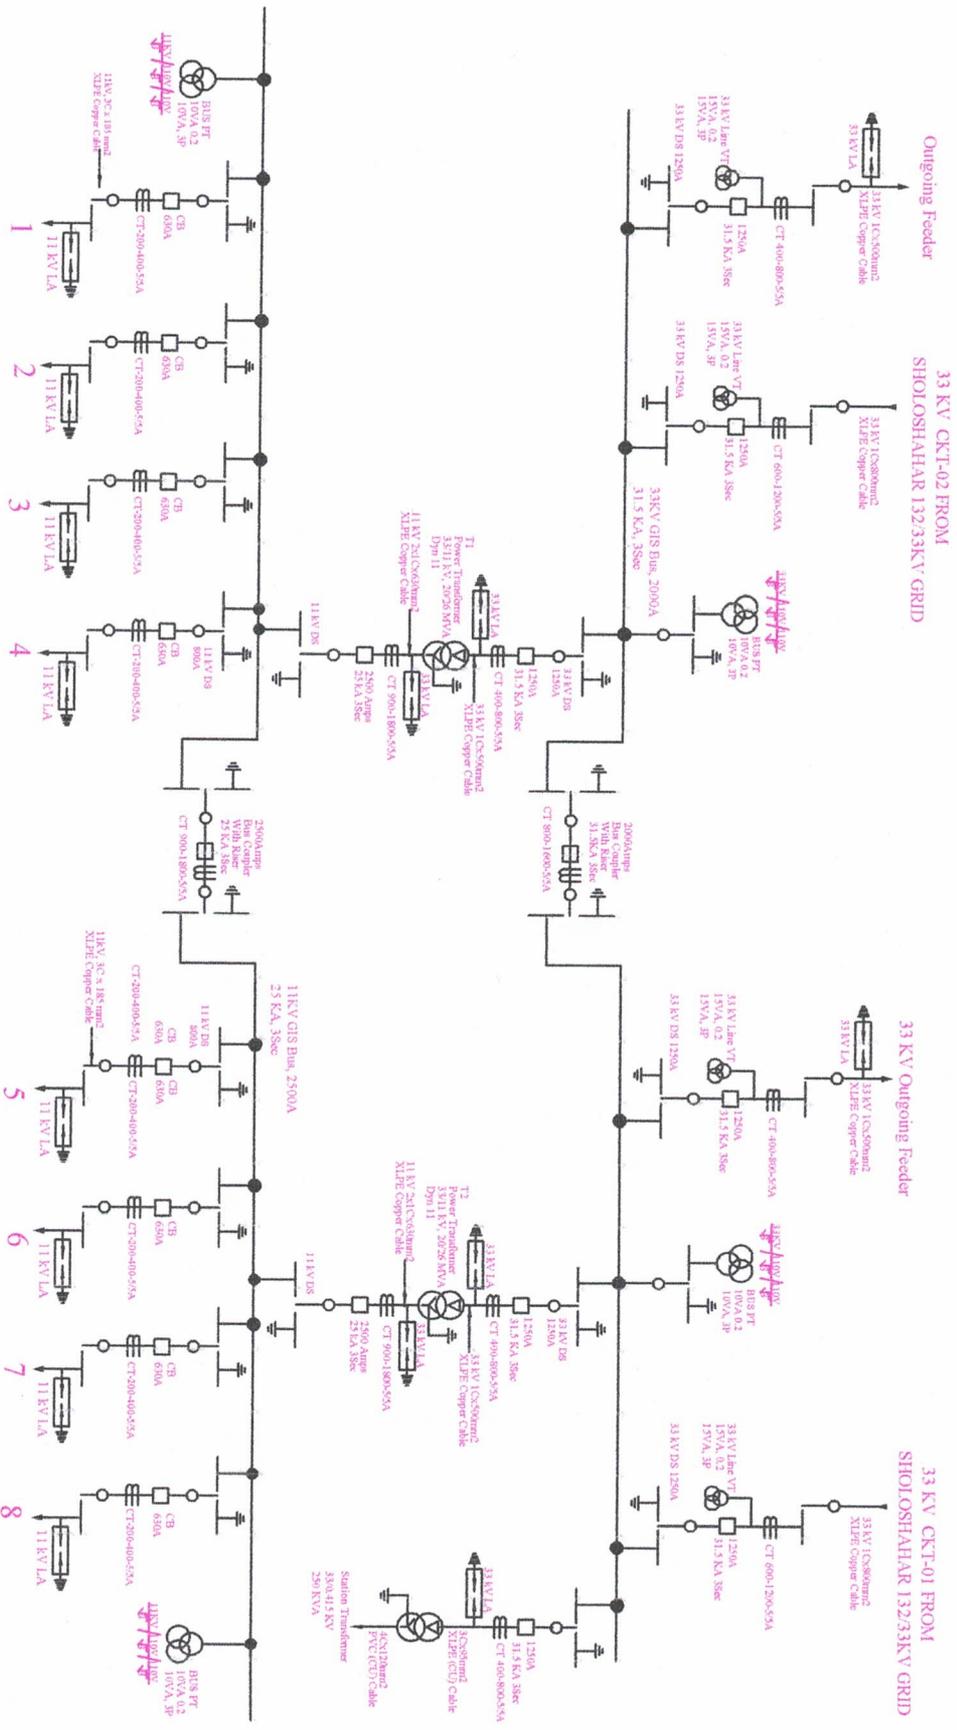

Sofyan
20/07/22


Engr. Satyendra Nath Chakraborty
Manager
Niaz & Associates Ltd.

SK

| | |
|--------------|---|
| Project : | Power Distribution System Development Chattergan Zone (Zahid Prasad), 1977DS |
| Title : | Single Line Diagram of Bara 2x20/26 MVA GIS Sub-station |
| Consultant : | Niaz & Associates |
| Drawing No : | N-20 |
| REVISION : | 03 |
| Date : | 20.07 |

SINGLE LINE DIAGRAM OF PROPOSED MURADPUR NEW 33/11KV GIS SUBSTATION


Engr. Sayendra Nath Chakraborty
 Managing Director & T.L.
 Niaz & Associates Ltd.

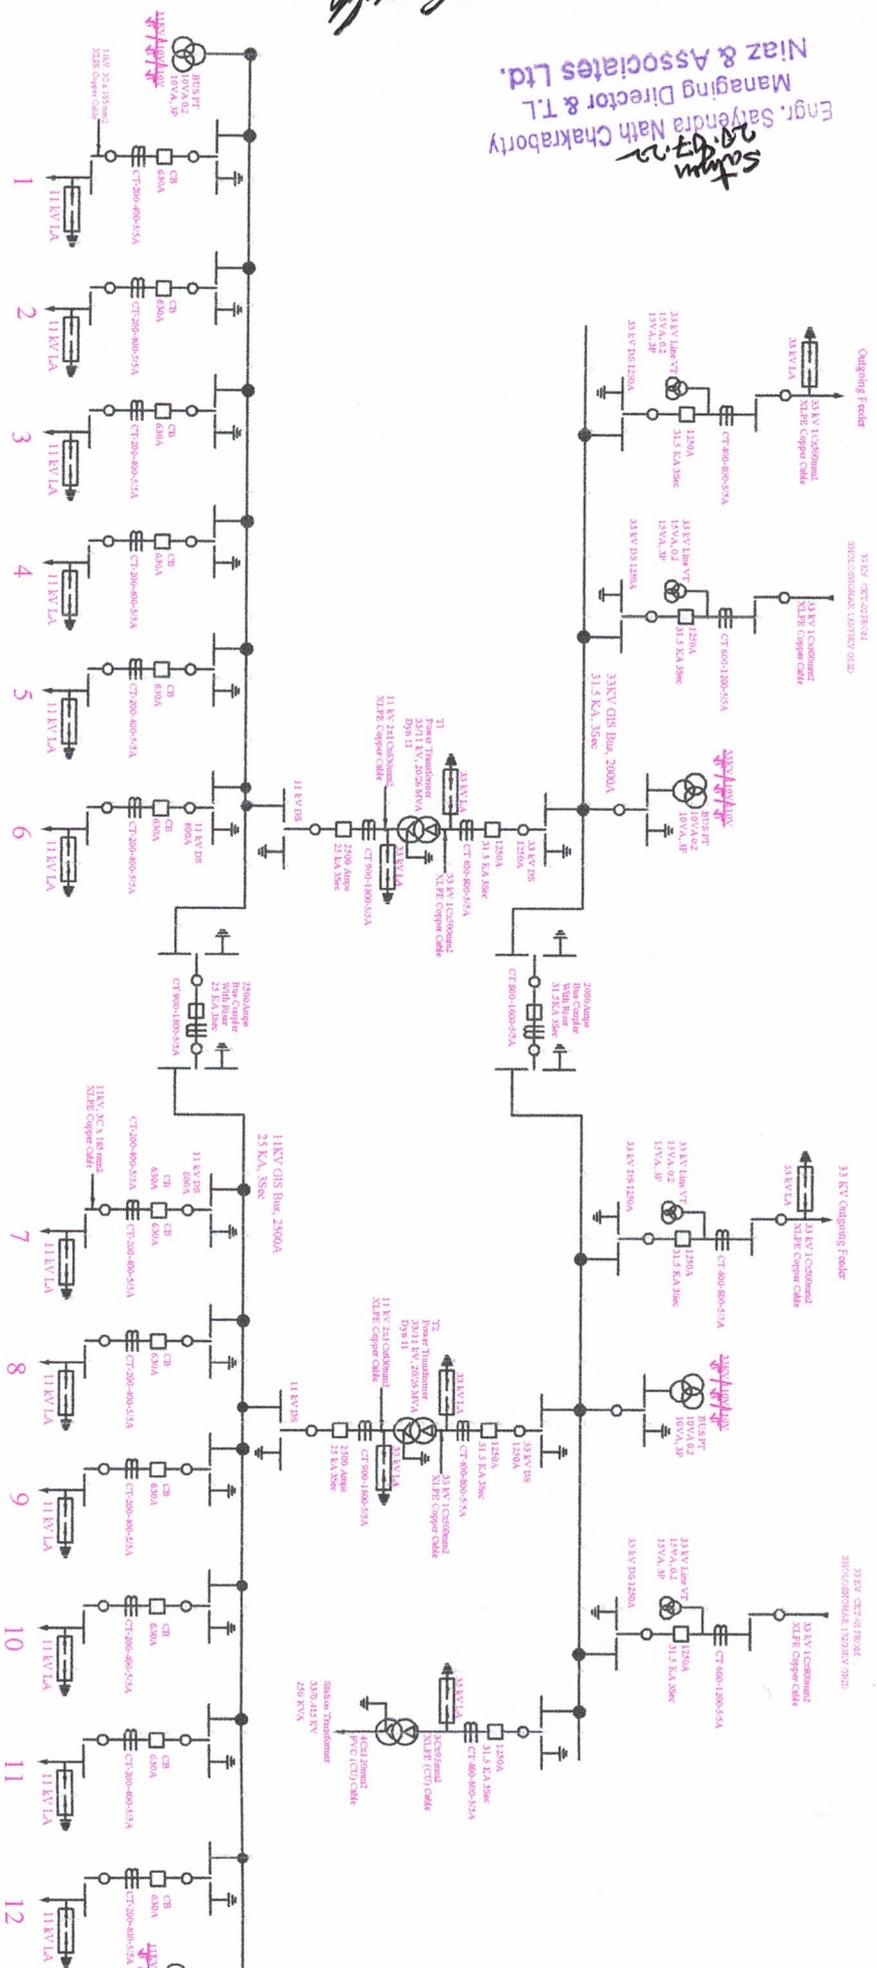

Signature

| | |
|-----------------|--|
| Project : | Power Distribution System Development Chandernagar Zone (Dadl Railway) BR |
| Title : | Single Line Diagram of 33/11KV GIS Sub-station |
| Consultant : | Niaz & Associates |
| Drawing No. N-5 | |
| Revision : 03 | |
| Date : | |

SINGLE LINE DIAGRAM OF UPGRADATION OF SHOLOSHAHAR 33/11KV GIS SUBSTATION (3150 Amper Double Bus)

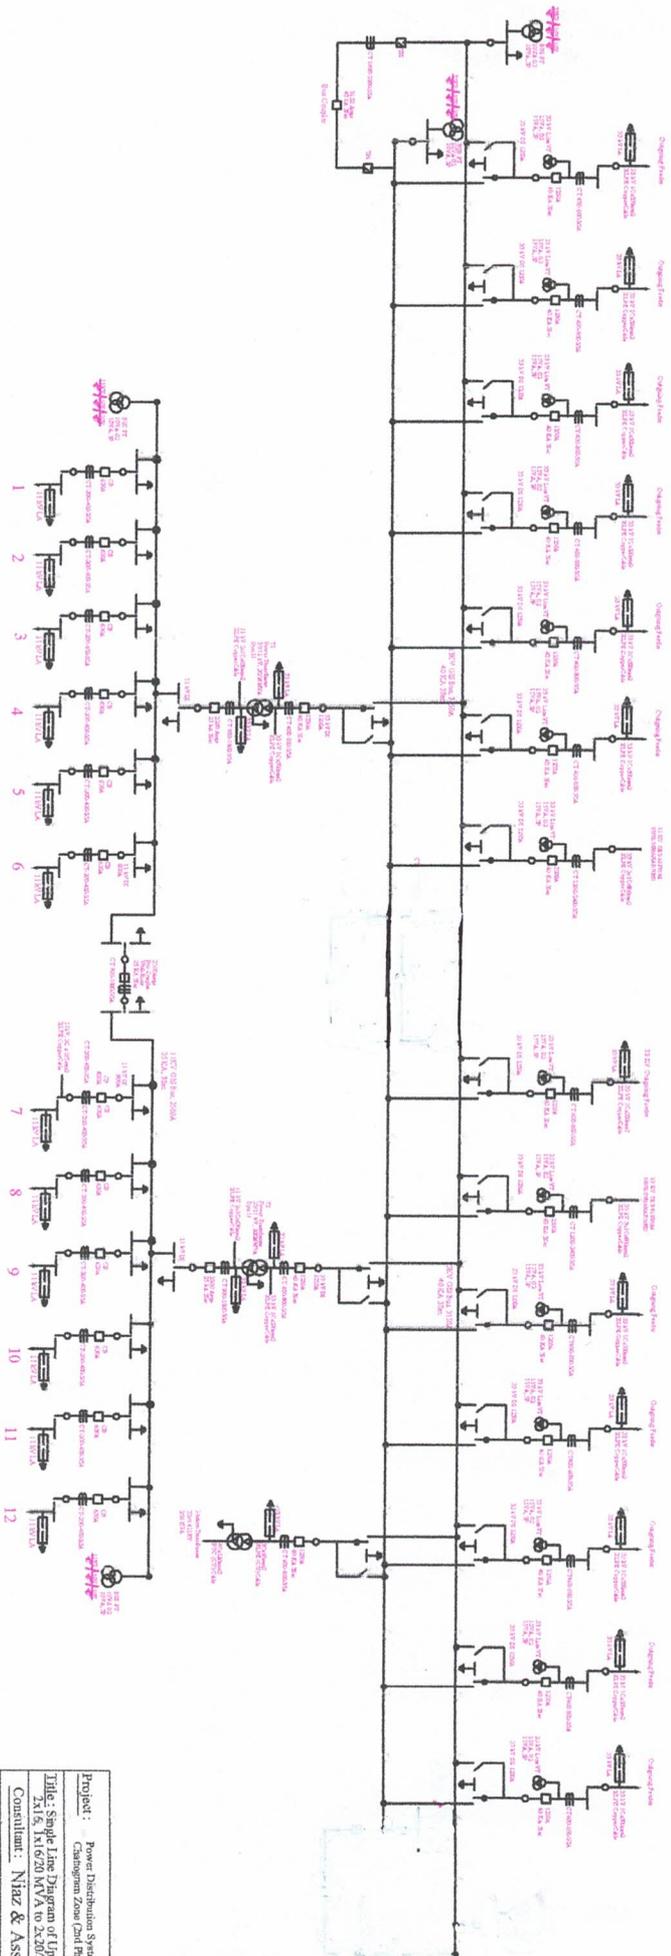

Engr. Satyendra Nath Chakraborty
 Managing Director & T.L.
 Niaz & Associates Ltd

Satyen
 25.08.22

Pranav
 28.08.22


Pranav

Pranav

INDICATIVE DRAWING

| | |
|-------------|--|
| Project: | Power Distribution System |
| Title: | Single Line Diagram of Upgradation of Sholoshahar 33/11KV GIS Substation |
| Consultant: | Niaz & Associates Ltd |
| Drawing No: | A-3 |
| Revision: | 04 |
| Date: | |

SINGLE LINE DIAGRAM OF BAY EXTENSION UNDER SHOLOSHAHAR 132/33 KV GRID SUB-STATION

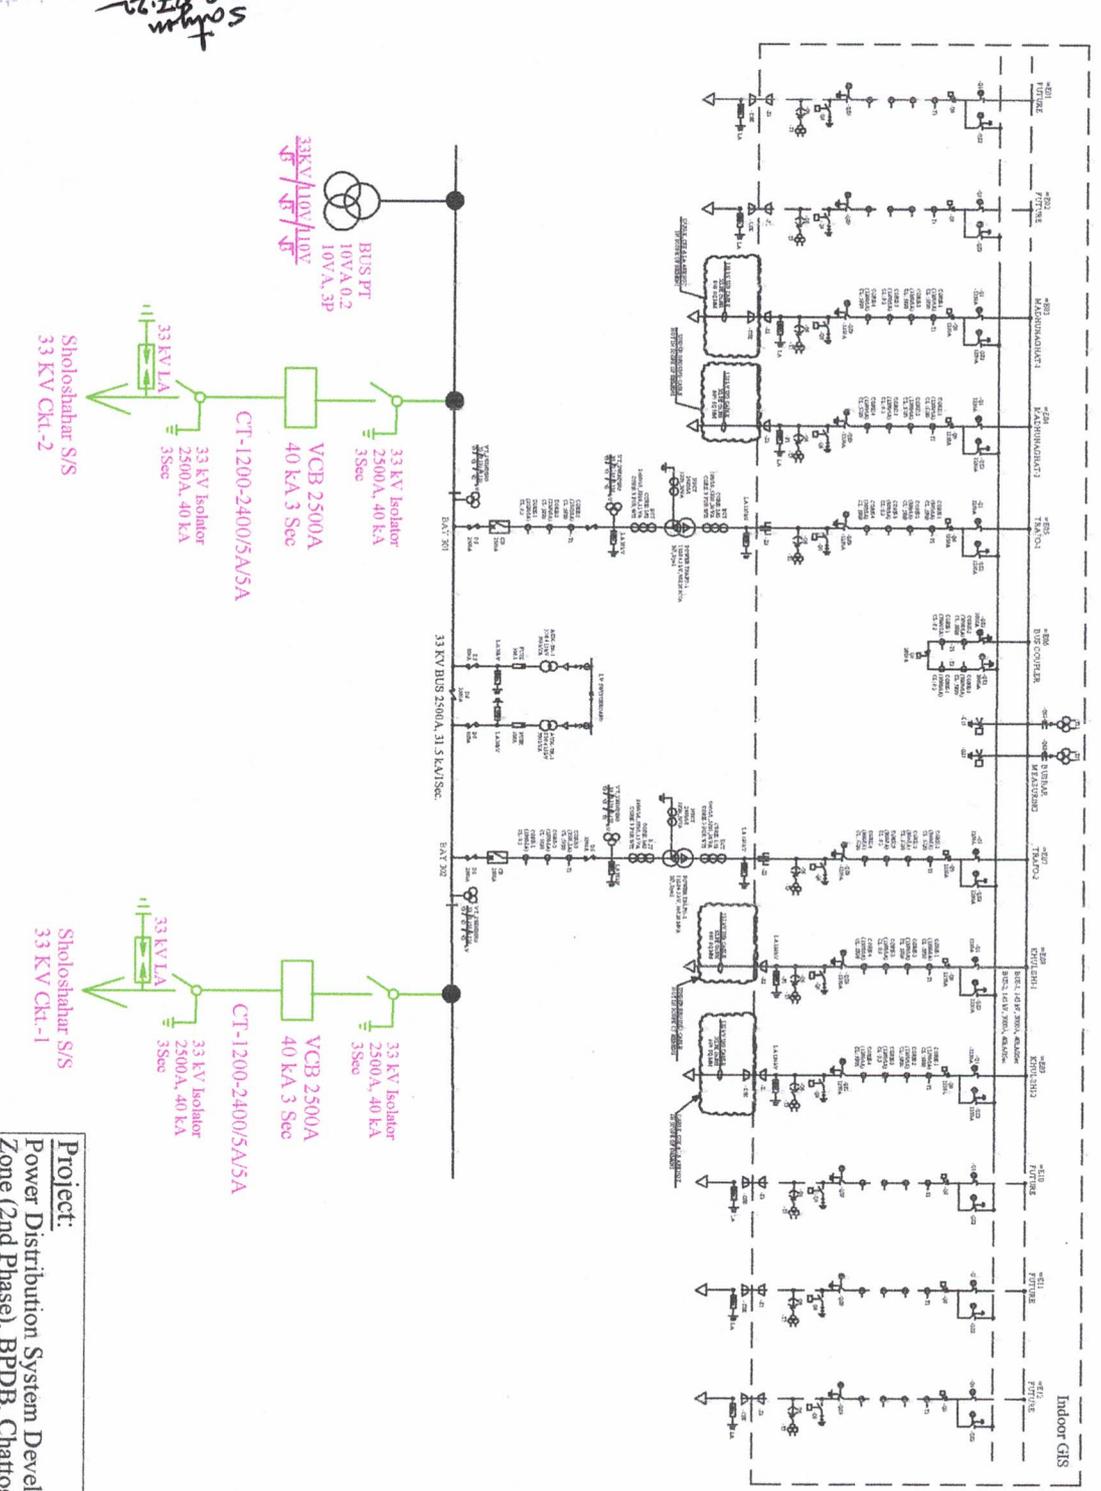

Soham
 20.07.22
 Engr. Satendra Nath Chakraborty
 Managing Director & T.E.
 Niaz & Associates Ltd.

| | |
|--|--|
| Project: | Power Distribution System Development Chattogram |
| Zone (2nd Phase), BPDB, Chattogram. | |
| Title : | Single Line Diagram of 33 KV 02 Bays Extension at Sholoshahar 132/33 KV Grid Substation. |
| Consultant : | Niaz & Associates Ltd. |
| Drawing No.: | G-2 |
| Revision : | 04 |
| Date: | 20.07.2022 |


[Handwritten Signature]

[Handwritten Signature]

SINGLE LINE DIAGRAM OF BAY EXTENSION UNDER KALURGHAT 132/33/11 KV GRID SUB-STATION

Engr. Satyendra Nath Chakraborty
Managing Director & T.L.
Niaz & Associates Ltd.

Signature

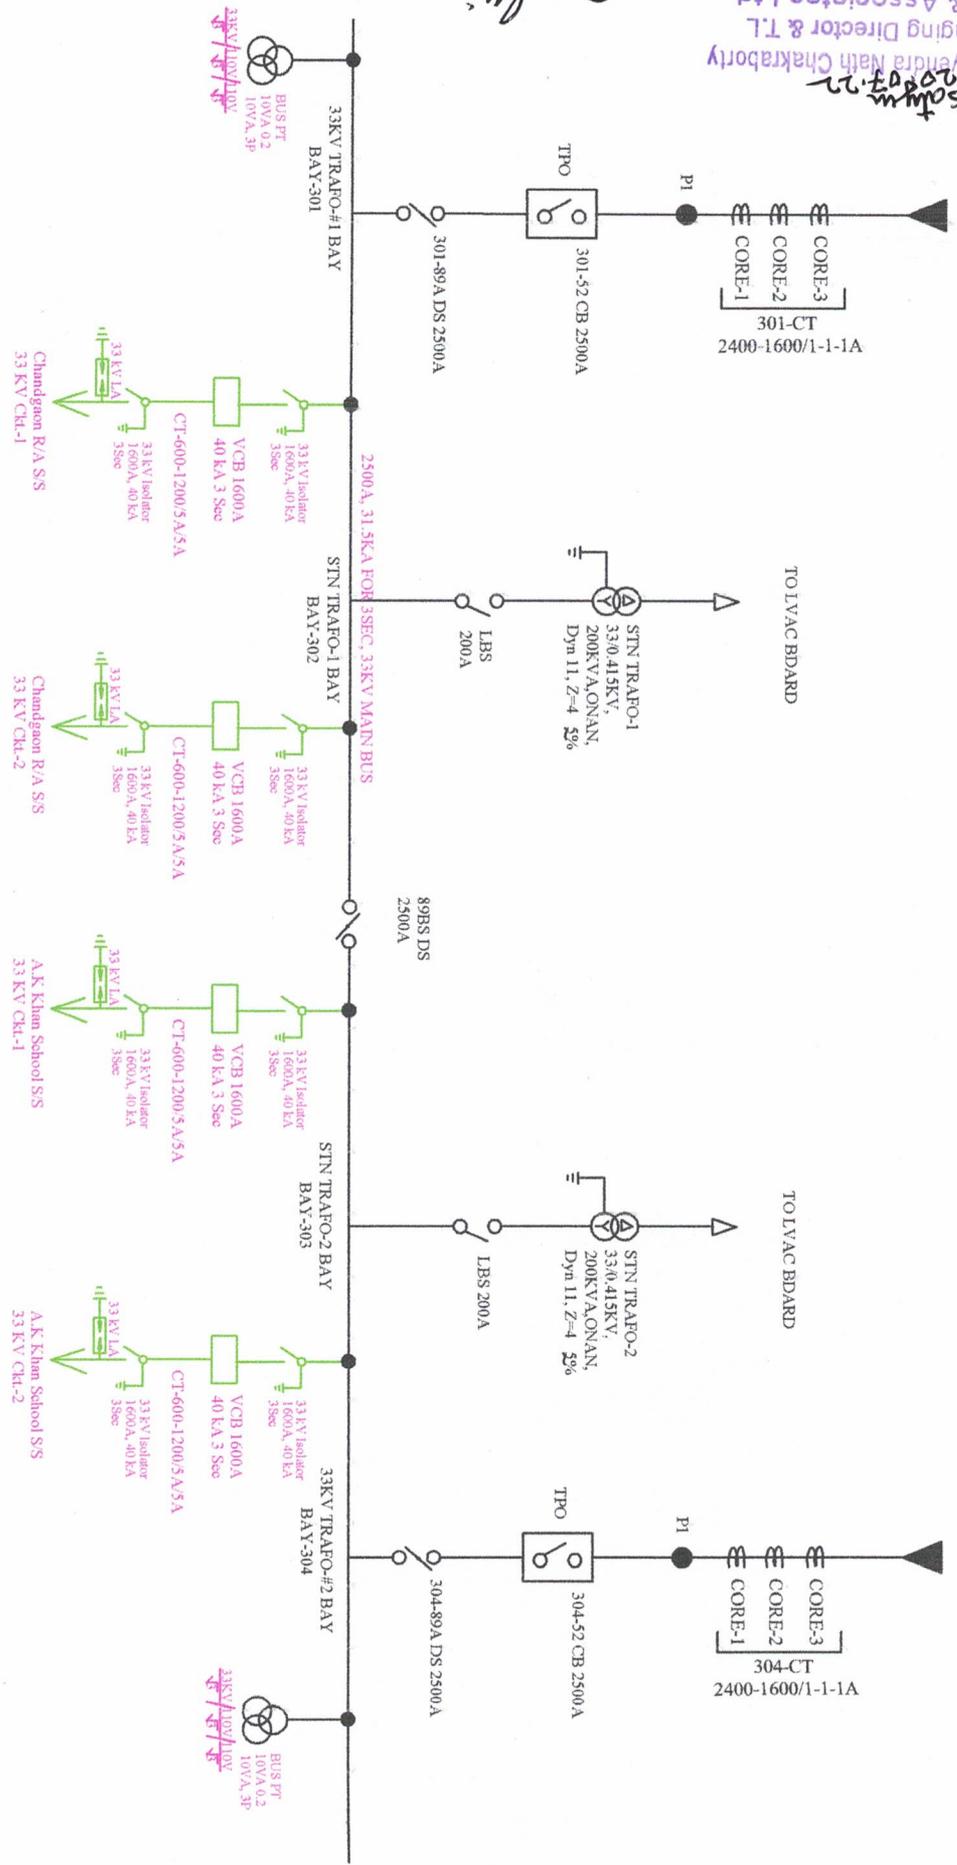

Signature

| | |
|---|------------------|
| Project: | |
| Power Distribution System Development Ch | |
| Zone (2nd Phase), BPDB, Chattogram. | |
| Title : Single Line Diagram of 33 KV 04 Bays Extens | |
| Kalurghat 132/33/11 KV Grid Substation. | |
| Consultant : Niaz & Associates Ltd. | |
| Drawing No. : G-4 | Date: 20.07.2022 |
| Revision : 04 | |