


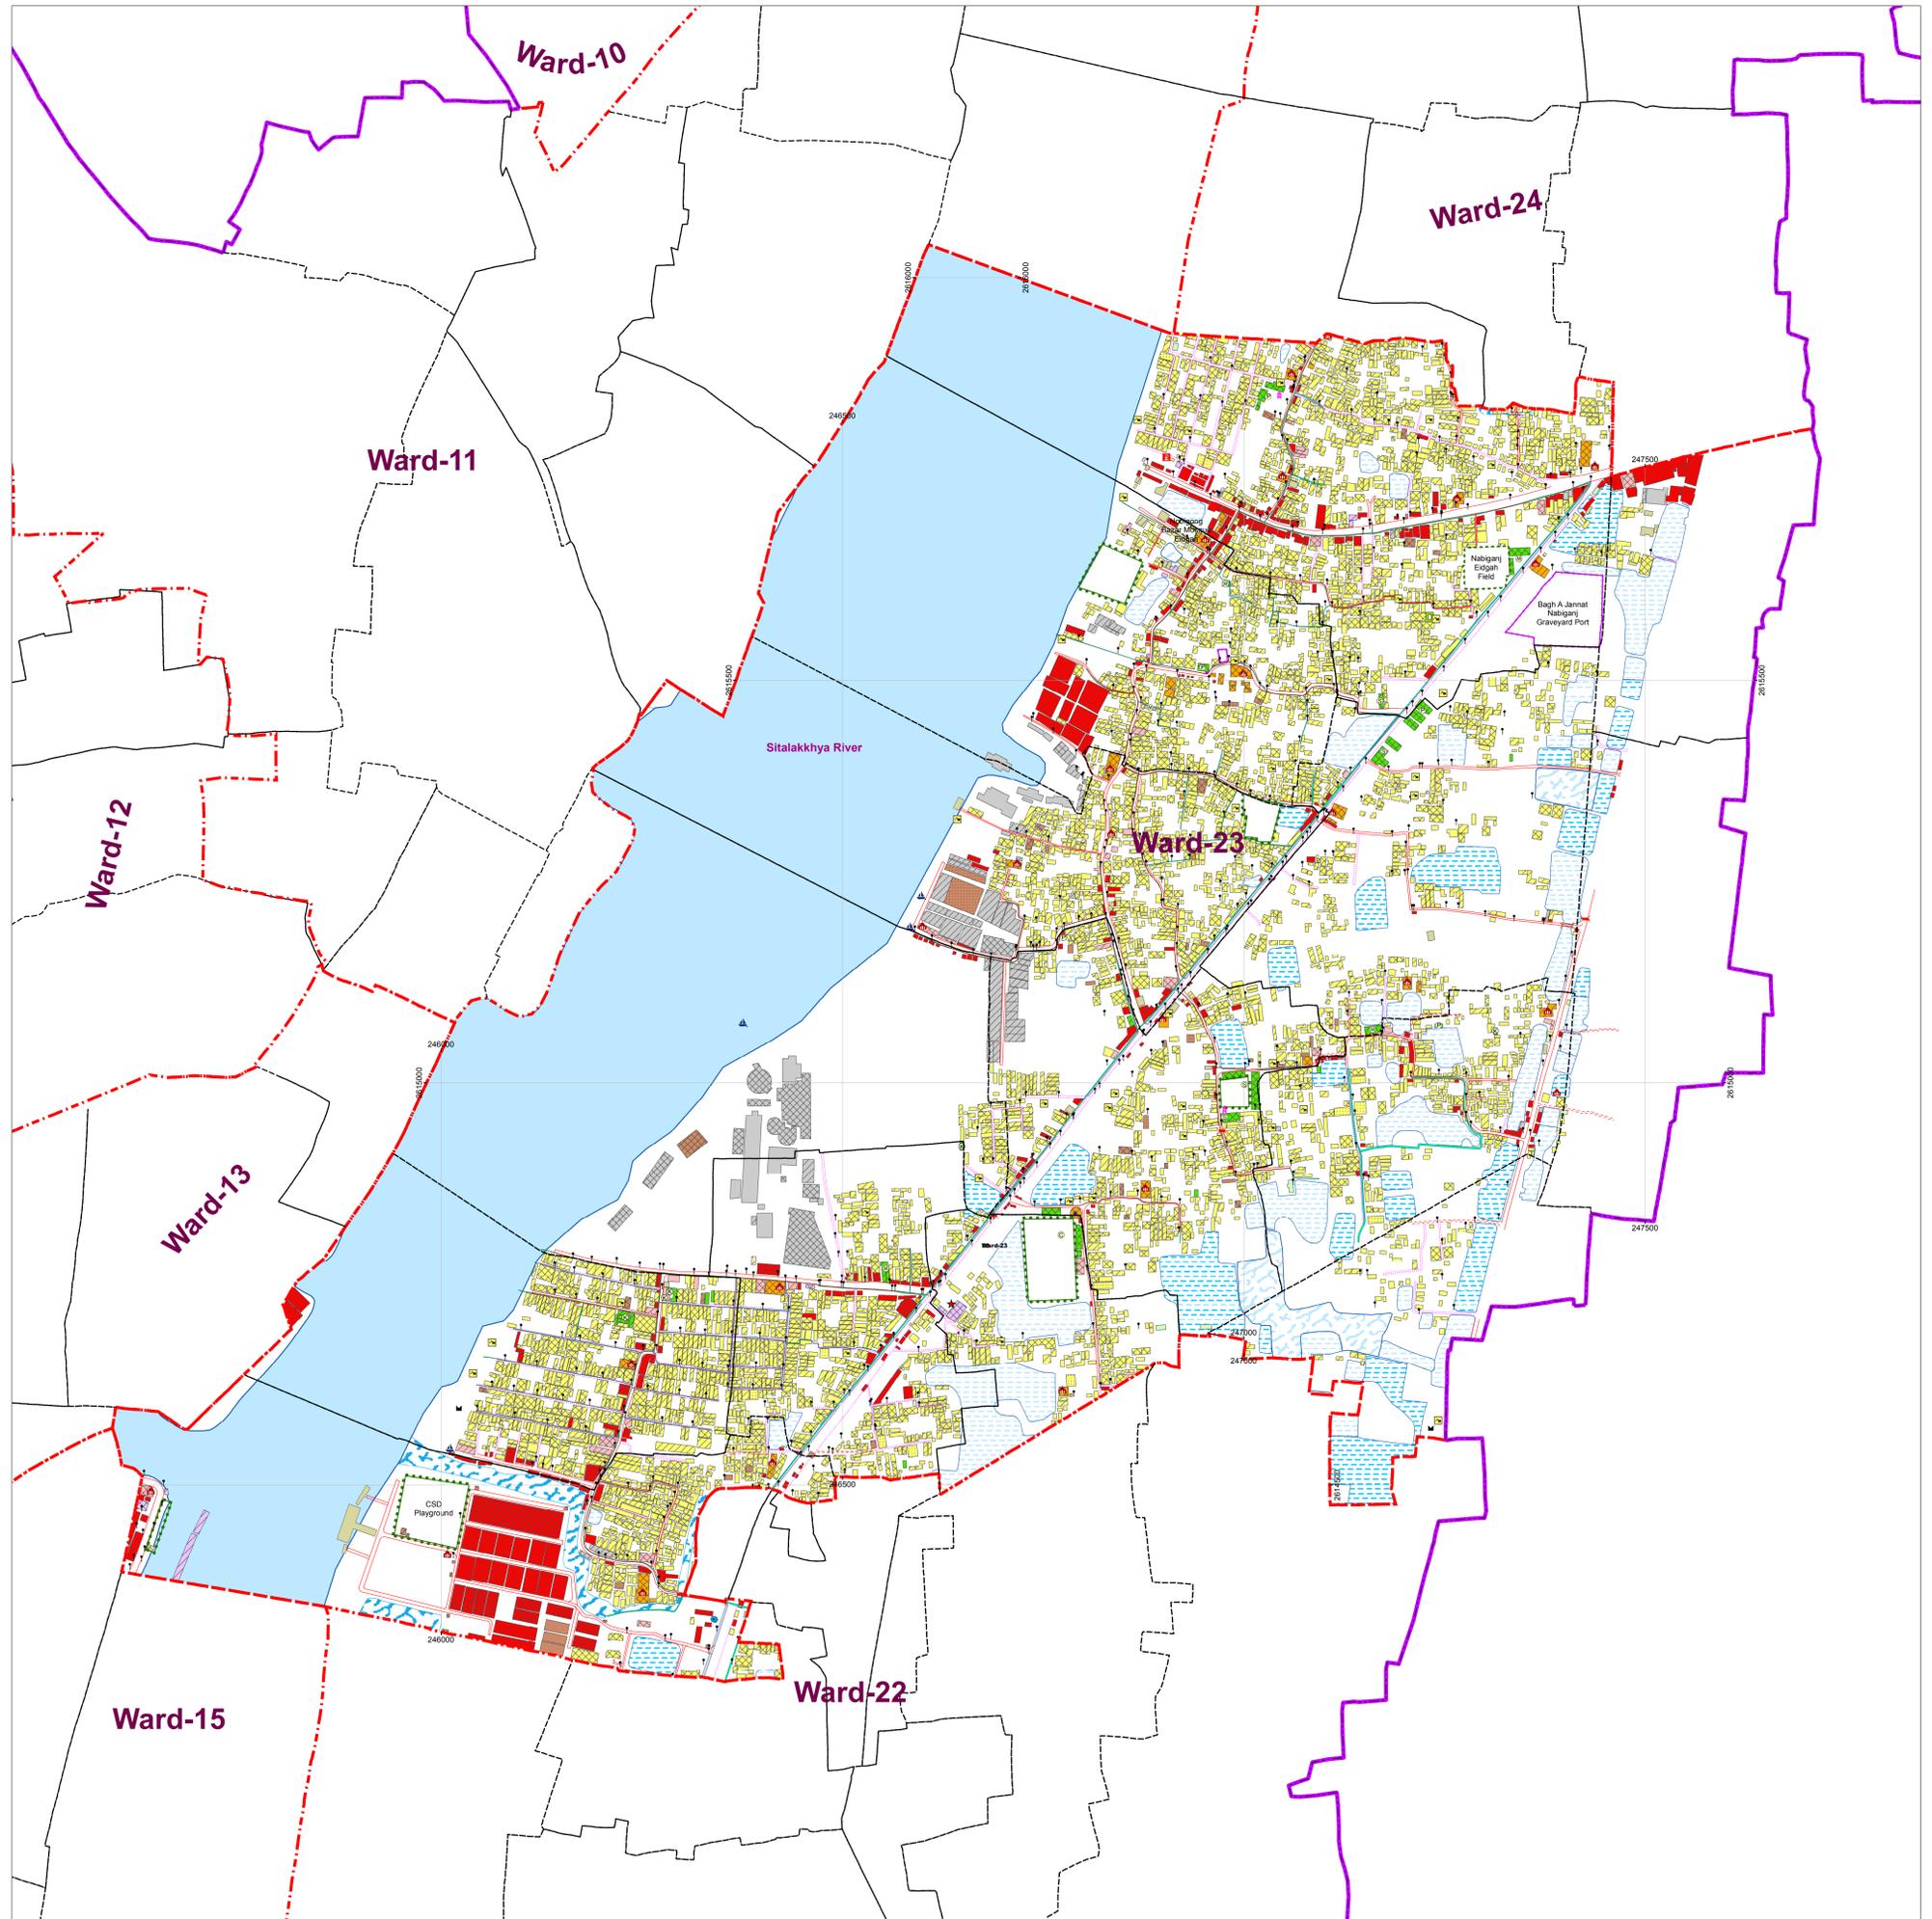

1:3400

 
PHYSICAL FEATURE SURVEY MAP (Ward Map)

Ward-23



CONSULTANT
 **Development Design Consultants Ltd.**
 47 Mohakhali C/A, Dhaka 1212, Bangladesh


PREPARATION OF ACTION AREA PLAN FOR NARAYANGANJ CITY CORPORATION



Scale 1:990 or 1cm = 25.15 m or 1" = 82.5 ft

Government of the People's Republic of Bangladesh
 Ministry of Local Government, Rural Development and Cooperatives
 Local Government Division

Local Government Engineering Department (LGED)
 Preparation of Action Area Plan Narayanganj City Corporation (NCC)

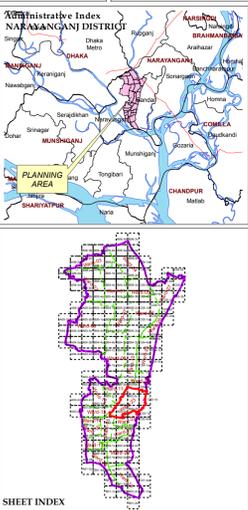

LEGEND	
	City Corporation Boundary
	Ward Boundary
	Mauza Boundary
	Mauza Plot Boundary
	1990 Grid Boundary
	Divisional Headquarter
	Zila Parishad Office
	City Corporation Office
	District Headquarter (DC Office)
	Upazila Headquarter
	Union Parishad Office (Defunct)
	Road (Pucca)
	Road (Semi-pucca)
	Road (Katcha)
	Footpath
	Road Island
	Drain (Pucca)
	Drain (Katcha)
	Railway
	Embankment
	Right of Way
	High Volt Electric Line
	Boundary Wall
	Water Supply Line
	Dustbin
	Electric Pole
	Electric Transformer
	Light Post
	Garbage Disposal Site
	Monument, Shahid Minar
	Bus Terminal
	Truck Terminal
	Railway Station
	High-Volt Electric Tower
	Mobile Tower
	TV/Radio Tower
	Telephone Tower
	Wireless Tower
	Traffic Signal Post
	Telephone Box
	Telephone Pole
	Water Reservoir
	Overhead Tank
	Deep Tube Well/Water Pump House
	Bridge
	Culvert
	Foot-over Bridge
	Rail Gate
	Railway Bridge
	Railway Over Bridge
	Sluice Gate
	Museum
	Historic Sites
	Auditorium, Cinema Hall, Theater Hall
	Kindergarten/Nursery School
	Primary School
	High School
	High School & College
	Madrasa
	College
	NGO School/Other School
	University
	Refueling Station
	Fire Service
	Police Box
	Police Station
	Post Office/Post Box
	Power Plant/Electric Sub-Station
	Katcha/Tin Shed
	Semi-pucca
	Pucca
	Under Construction
	Agriculture
	Commercial Activities
	Education and Research
	Government Office
	Health Facilities
	Industrial Activities
	Miscellaneous Use
	Mixed Use
	Private Office
	Recreational Facilities
	Religious Facilities
	Residential & Homestead
	Restricted Area
	Warehouse
	Transport and Communication
	Brickfield
	Bus/Truck Terminal
	Chattal
	Eidgah
	Electric Sub-Station/Power Station
	Forestland
	Gravelyard/Cemetery/Crematorium
	Park/Playground/Stadium
	Restricted Area
	Railway Station
	Water Treatment Plant
	Waste Disposal Area
	Marshland/Beel
	Borrow Pits
	Lake
	Pond
	Ditch
	Canal/Irrigation Canal
	River
	Char

Note: Floor number of Single-storied structures is not labelled

Data Source
 RS Mauza Maps, Directorate of Land Records and Survey (DLRS), GoB.

Reference Bench Mark (RM)
 Horizontal: EPSG-3246 for Latitude/Northing & Longitude/Easting
 Vertical: GTS-5153, BM-7201, BM-6205, BM-701 and BM-702 for Reduce Level (RL) adjustment.

Projection System: Universal Transverse Mercator coordinate system (UTM)
 Spheroid : WGS84 Parameters : 1st standard parallel : 23 09 00 (dd mm ss)
 Datum : WGS84 2nd standard parallel : 28 48 00 (dd mm ss)
 Units : Meters Central Meridian : 90 00 00 (dd mm ss)
 Latitude of projection's origin : 00 00 00 (dd mm ss)
 False Easting : 500000 (m)
 False Northing : 0.0 (m)

Survey Period : September-December 2015
Date of Field Checking : January 2016
Map Print : January 2016

Development Design Consultants Ltd.	
(Md. Nasim Haider) CDS Specialist Preparation of Action Area Plan for Narayanganj and Gazipur City Corporation Project	(Dr. Md. Jahurul Hoque) Team Leader Preparation of Action Area Plan for Narayanganj and Gazipur City Corporation Project
Local Government Engineering Department (LGED)	
(Bivash Das) Urban Planner Preparation of Action Area Plan for Narayanganj and Gazipur City Corporation Project	(Md. Abdus Salam Mandal) Project Director of Long Bridge Construction Project on Upazila and Union Road, Narayanganj and Gazipur City Corporation Project
Narayanganj City Corporation	
(Planner Md. Moimul Islam) Urban Planner, Narayanganj City Corporation	(Md. Mostafa Kamal Mazumder) Chief Executive Officer, Narayanganj City Corporation